


November 14, 2019
 UNAUTHORIZED CHANGES & USES: M. Neils Engineering, Inc. preparing these plans will not be responsible for, or liable for unauthorized changes to or uses to these plans. All changes to these plans must be in writing and must be approved by M. Neils Engineering, Inc.

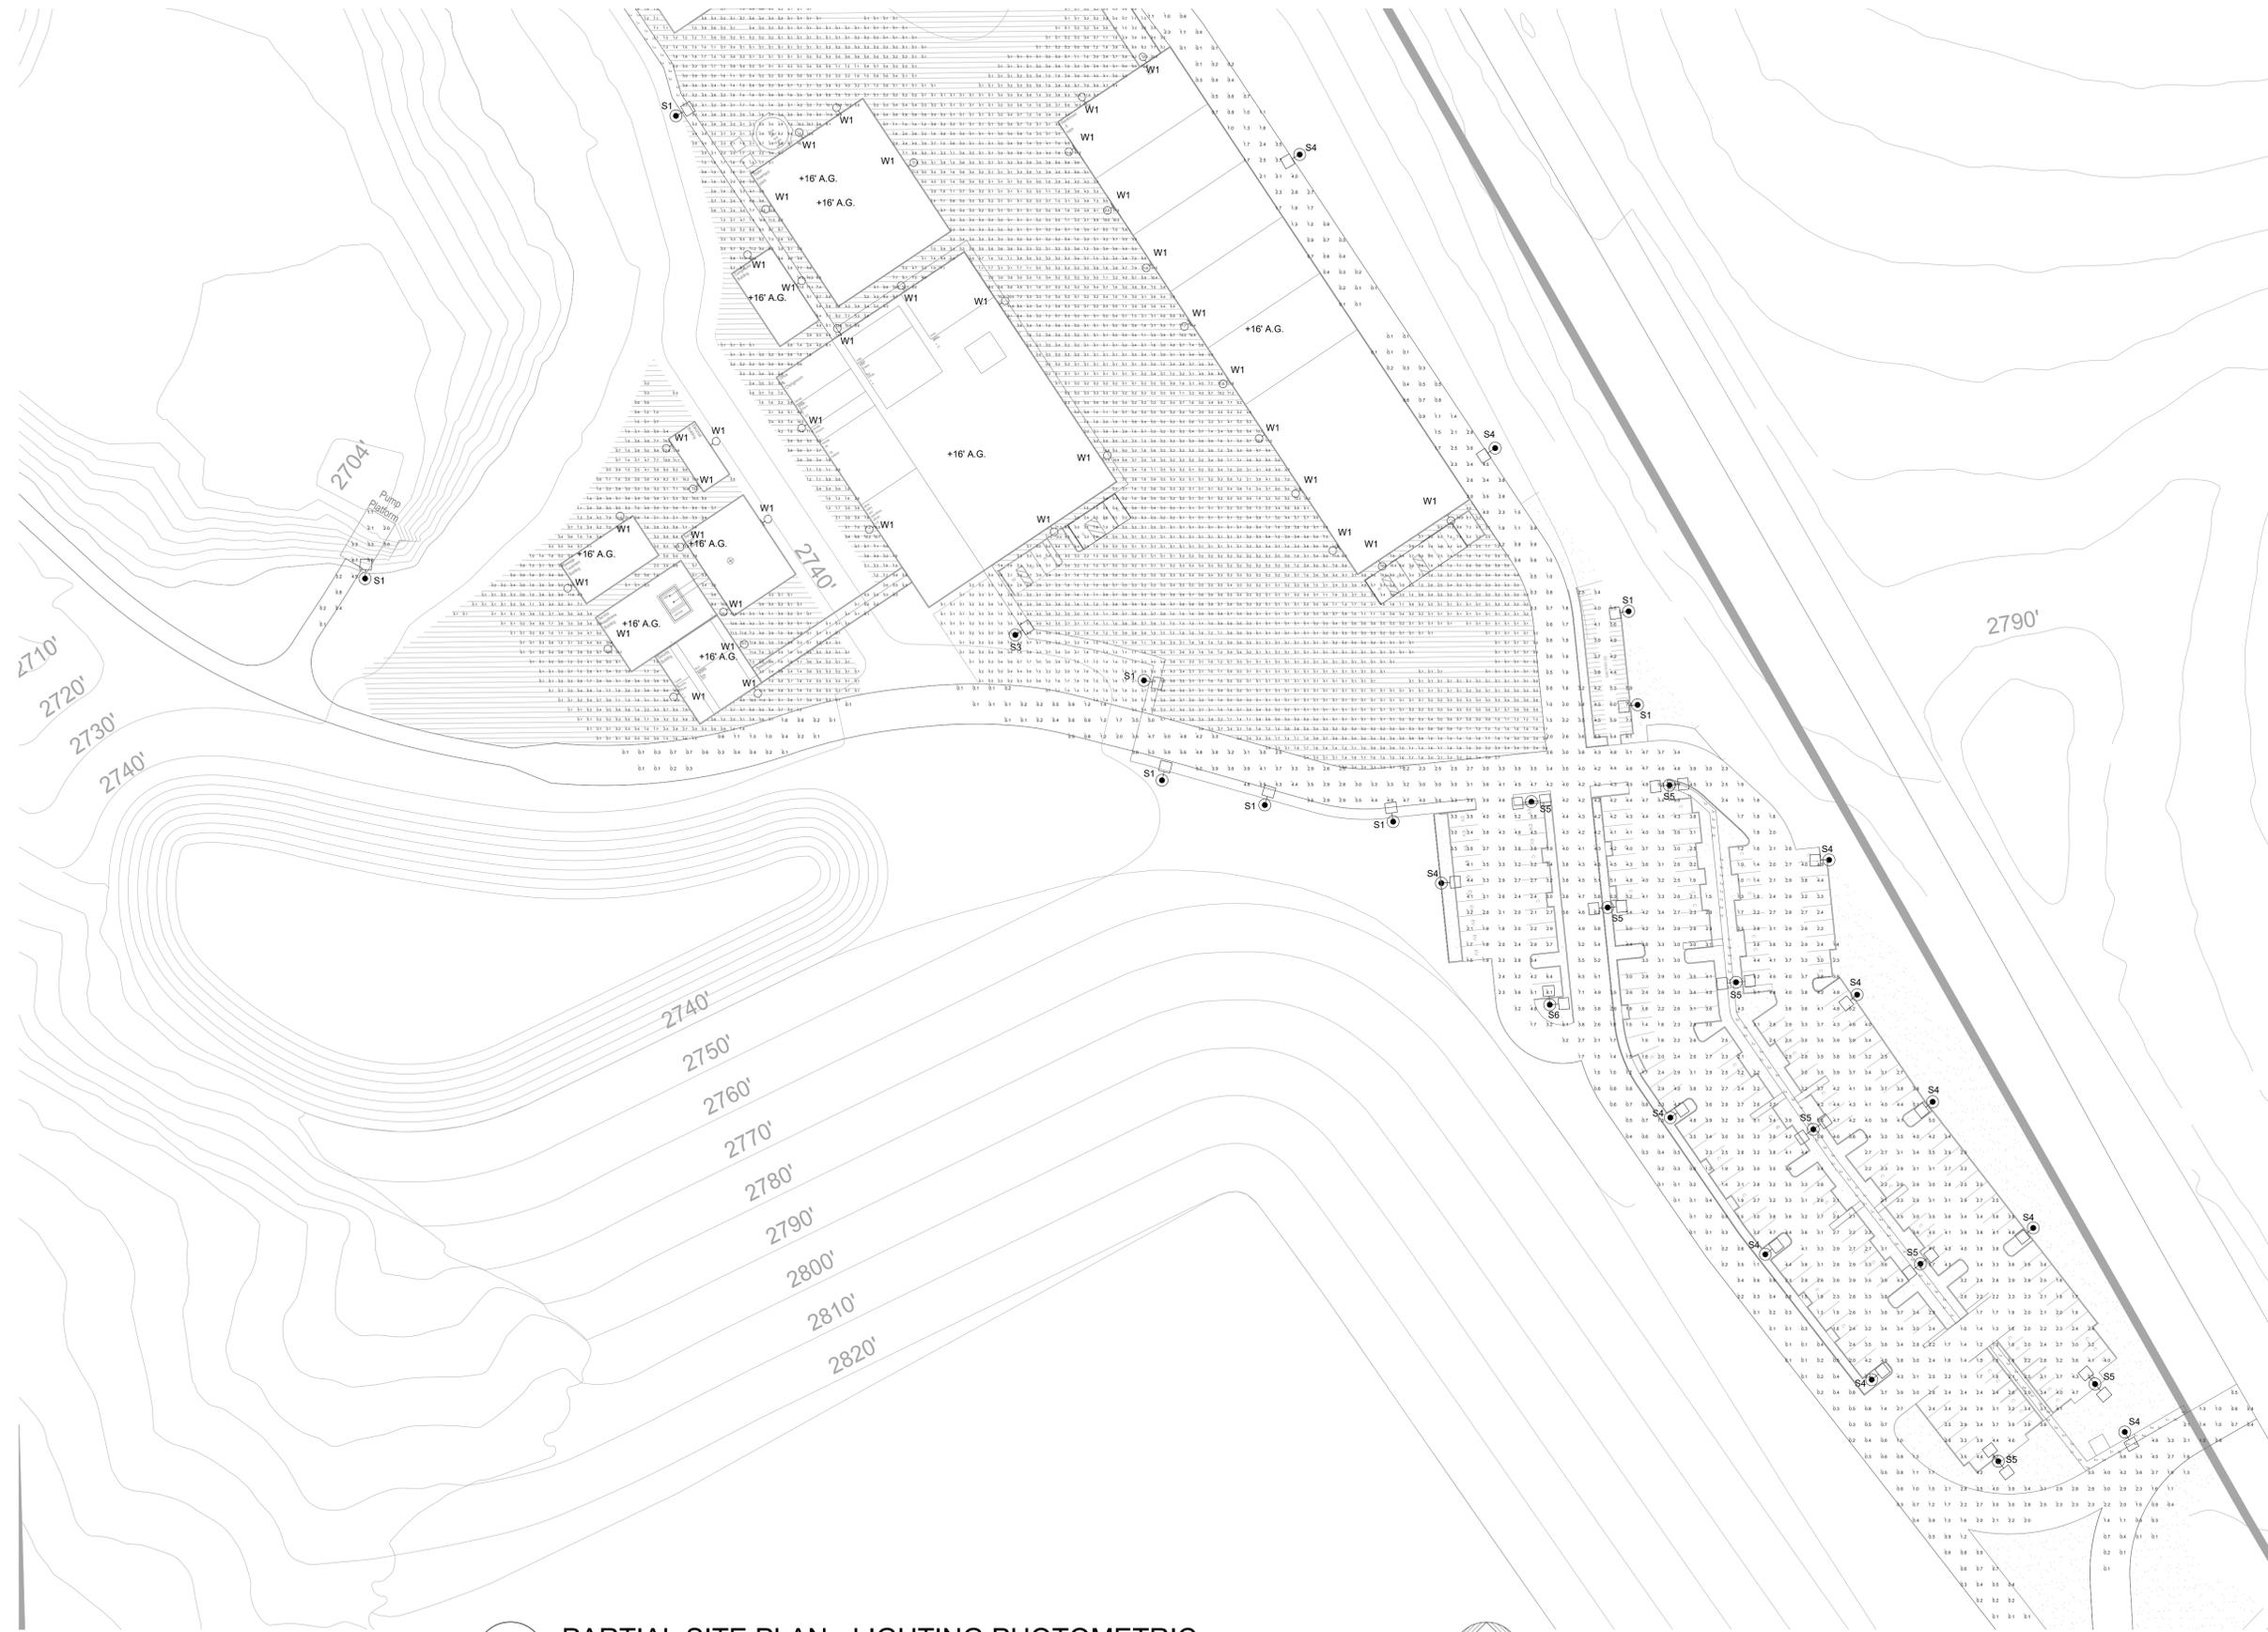

1 PARTIAL SITE PLAN - LIGHTING PHOTOMETRIC
 E100 SCALE: 1" = 50'-0"

No.	REVISIONS	DATE	BY
1		X/XX/XX	

M. NEILS
 ENGINEERING, INC.
 Electrical Engineers | Lighting Designers
 100 Howe Ave., Suite 215N
 Sacramento, CA 95825-8217
 www.mneilsengineering.com
 Tel: (916) 923-4400 Fax: (916) 923-4410
 PROJECT #: 19301.21



SHEET TITLE:
**PARTIAL SITE PLAN -
 LIGHTING
 PHOTOMETRIC**

PROJECT:
**Idaho-Maryland Gold Project
 Rise Grass Valley Inc.
 PO Box 271
 Grass Valley, California, USA 95945**

Date:	11-11-19
Checked:	JUB
Drawn:	SG
Scale:	AS NOTED
Sheet	E100
Of	Sheets