


November 14, 2019  
 UNAUTHORIZED CHANGES & USES: M. Neils Engineering, Inc. preparing these plans will not be responsible for, or liable for unauthorized changes to or uses to these plans. All changes to these plans must be in writing and must be approved by M. Neils Engineering, Inc.

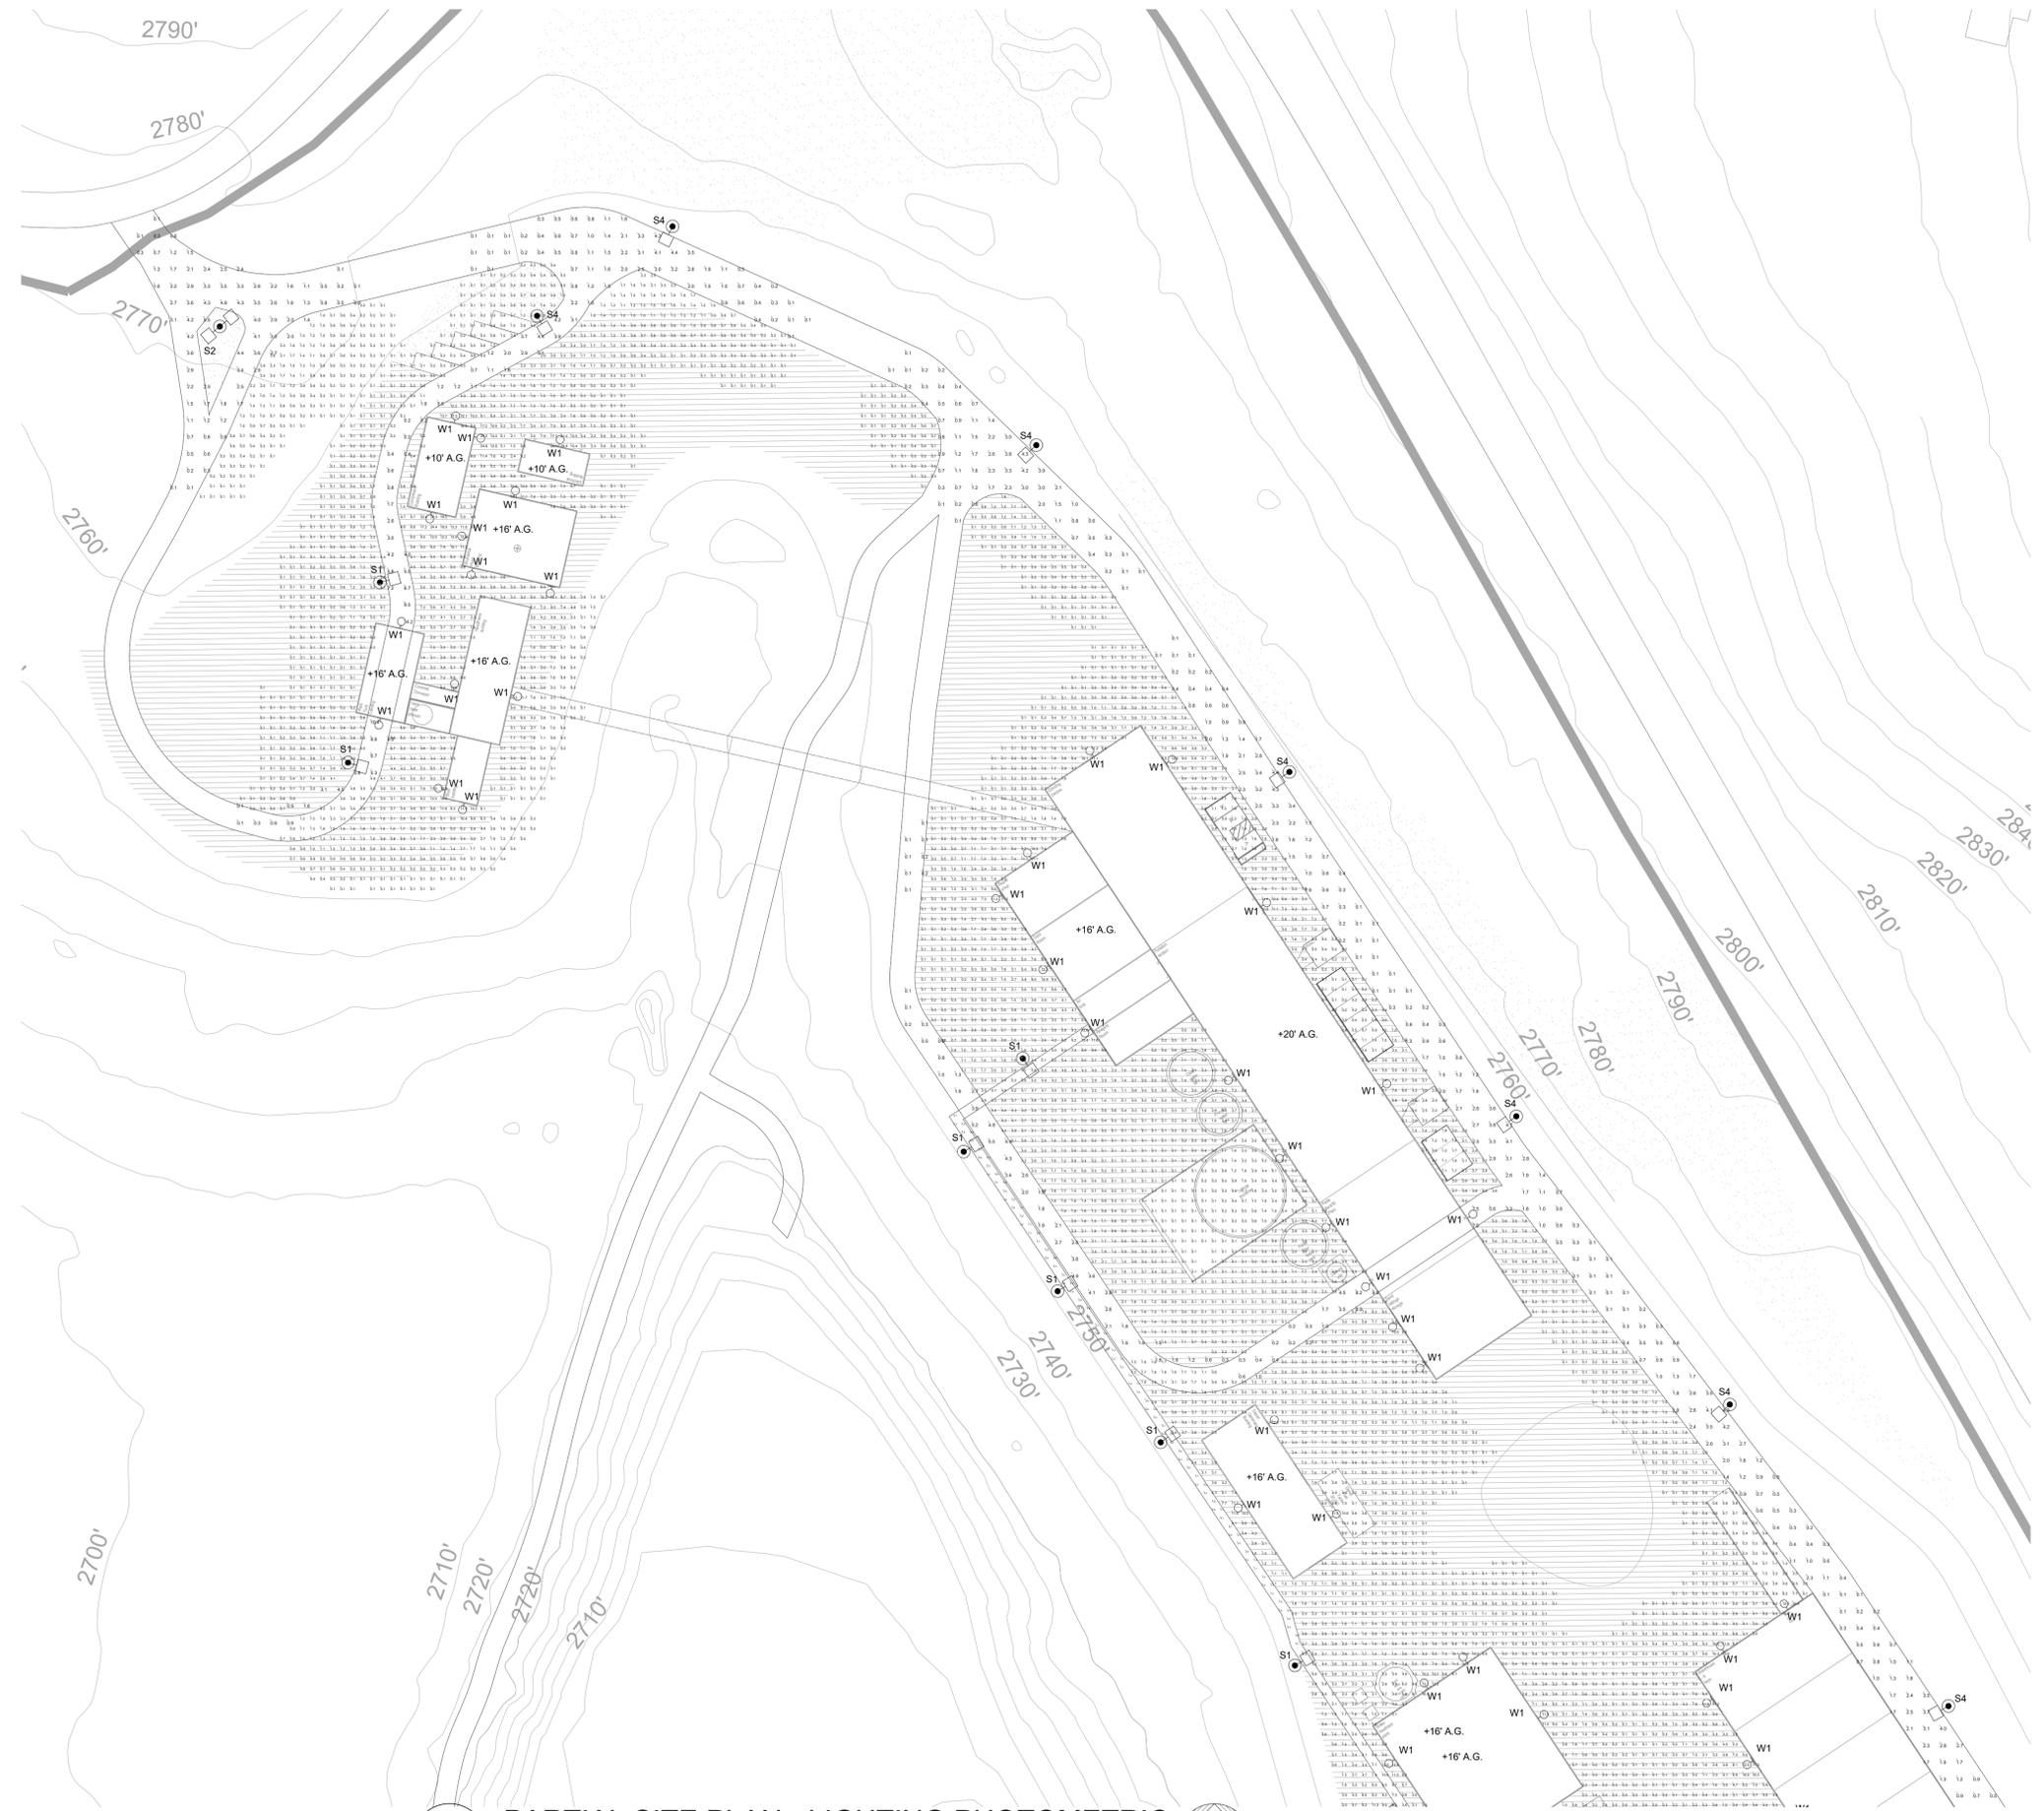

1 PARTIAL SITE PLAN - LIGHTING PHOTOMETRIC  
 E110 SCALE: 1" = 50'-0"

No.	REVISIONS	DATE	BY
1		X/XX/XX	

**M. NEILS**  
 ENGINEERING, INC.  
 Electrical Engineers | Lighting Designers  
 100 Howe Ave., Suite 235N  
 Sacramento, CA 95825-8217  
 www.mneilsengineering.com  
 Tel: (916) 923-4400 Fax: (916) 923-4410  
 PROJECT #: 19301.21

REGISTERED PROFESSIONAL ENGINEER  
 JESSE U. BASTIAN  
 No. E20229  
 Exp. 03-31-21  
 J. U. Bastian  
 STATE OF CALIFORNIA  
 11-11-19

SHEET TITLE:  
**PARTIAL SITE PLAN -  
 LIGHTING  
 PHOTOMETRIC**

PROJECT:  
**Idaho-Maryland Gold Project  
 Rise Grass Valley Inc.  
 PO Box 271  
 Grass Valley, California, USA 95945**

Date:	11-11-19
Checked:	JUB
Drawn:	SG
Scale:	AS NOTED
Sheet	<b>E110</b>
Of	Sheets