


January 17, 2020
UNAUTHORIZED CHANGES & USES: M. Neils Engineering, Inc. preparing these plans will not be responsible for, or liable for unauthorized changes to or uses to these plans. All changes to these plans must be in writing and must be approved by M. Neils Engineering, Inc.

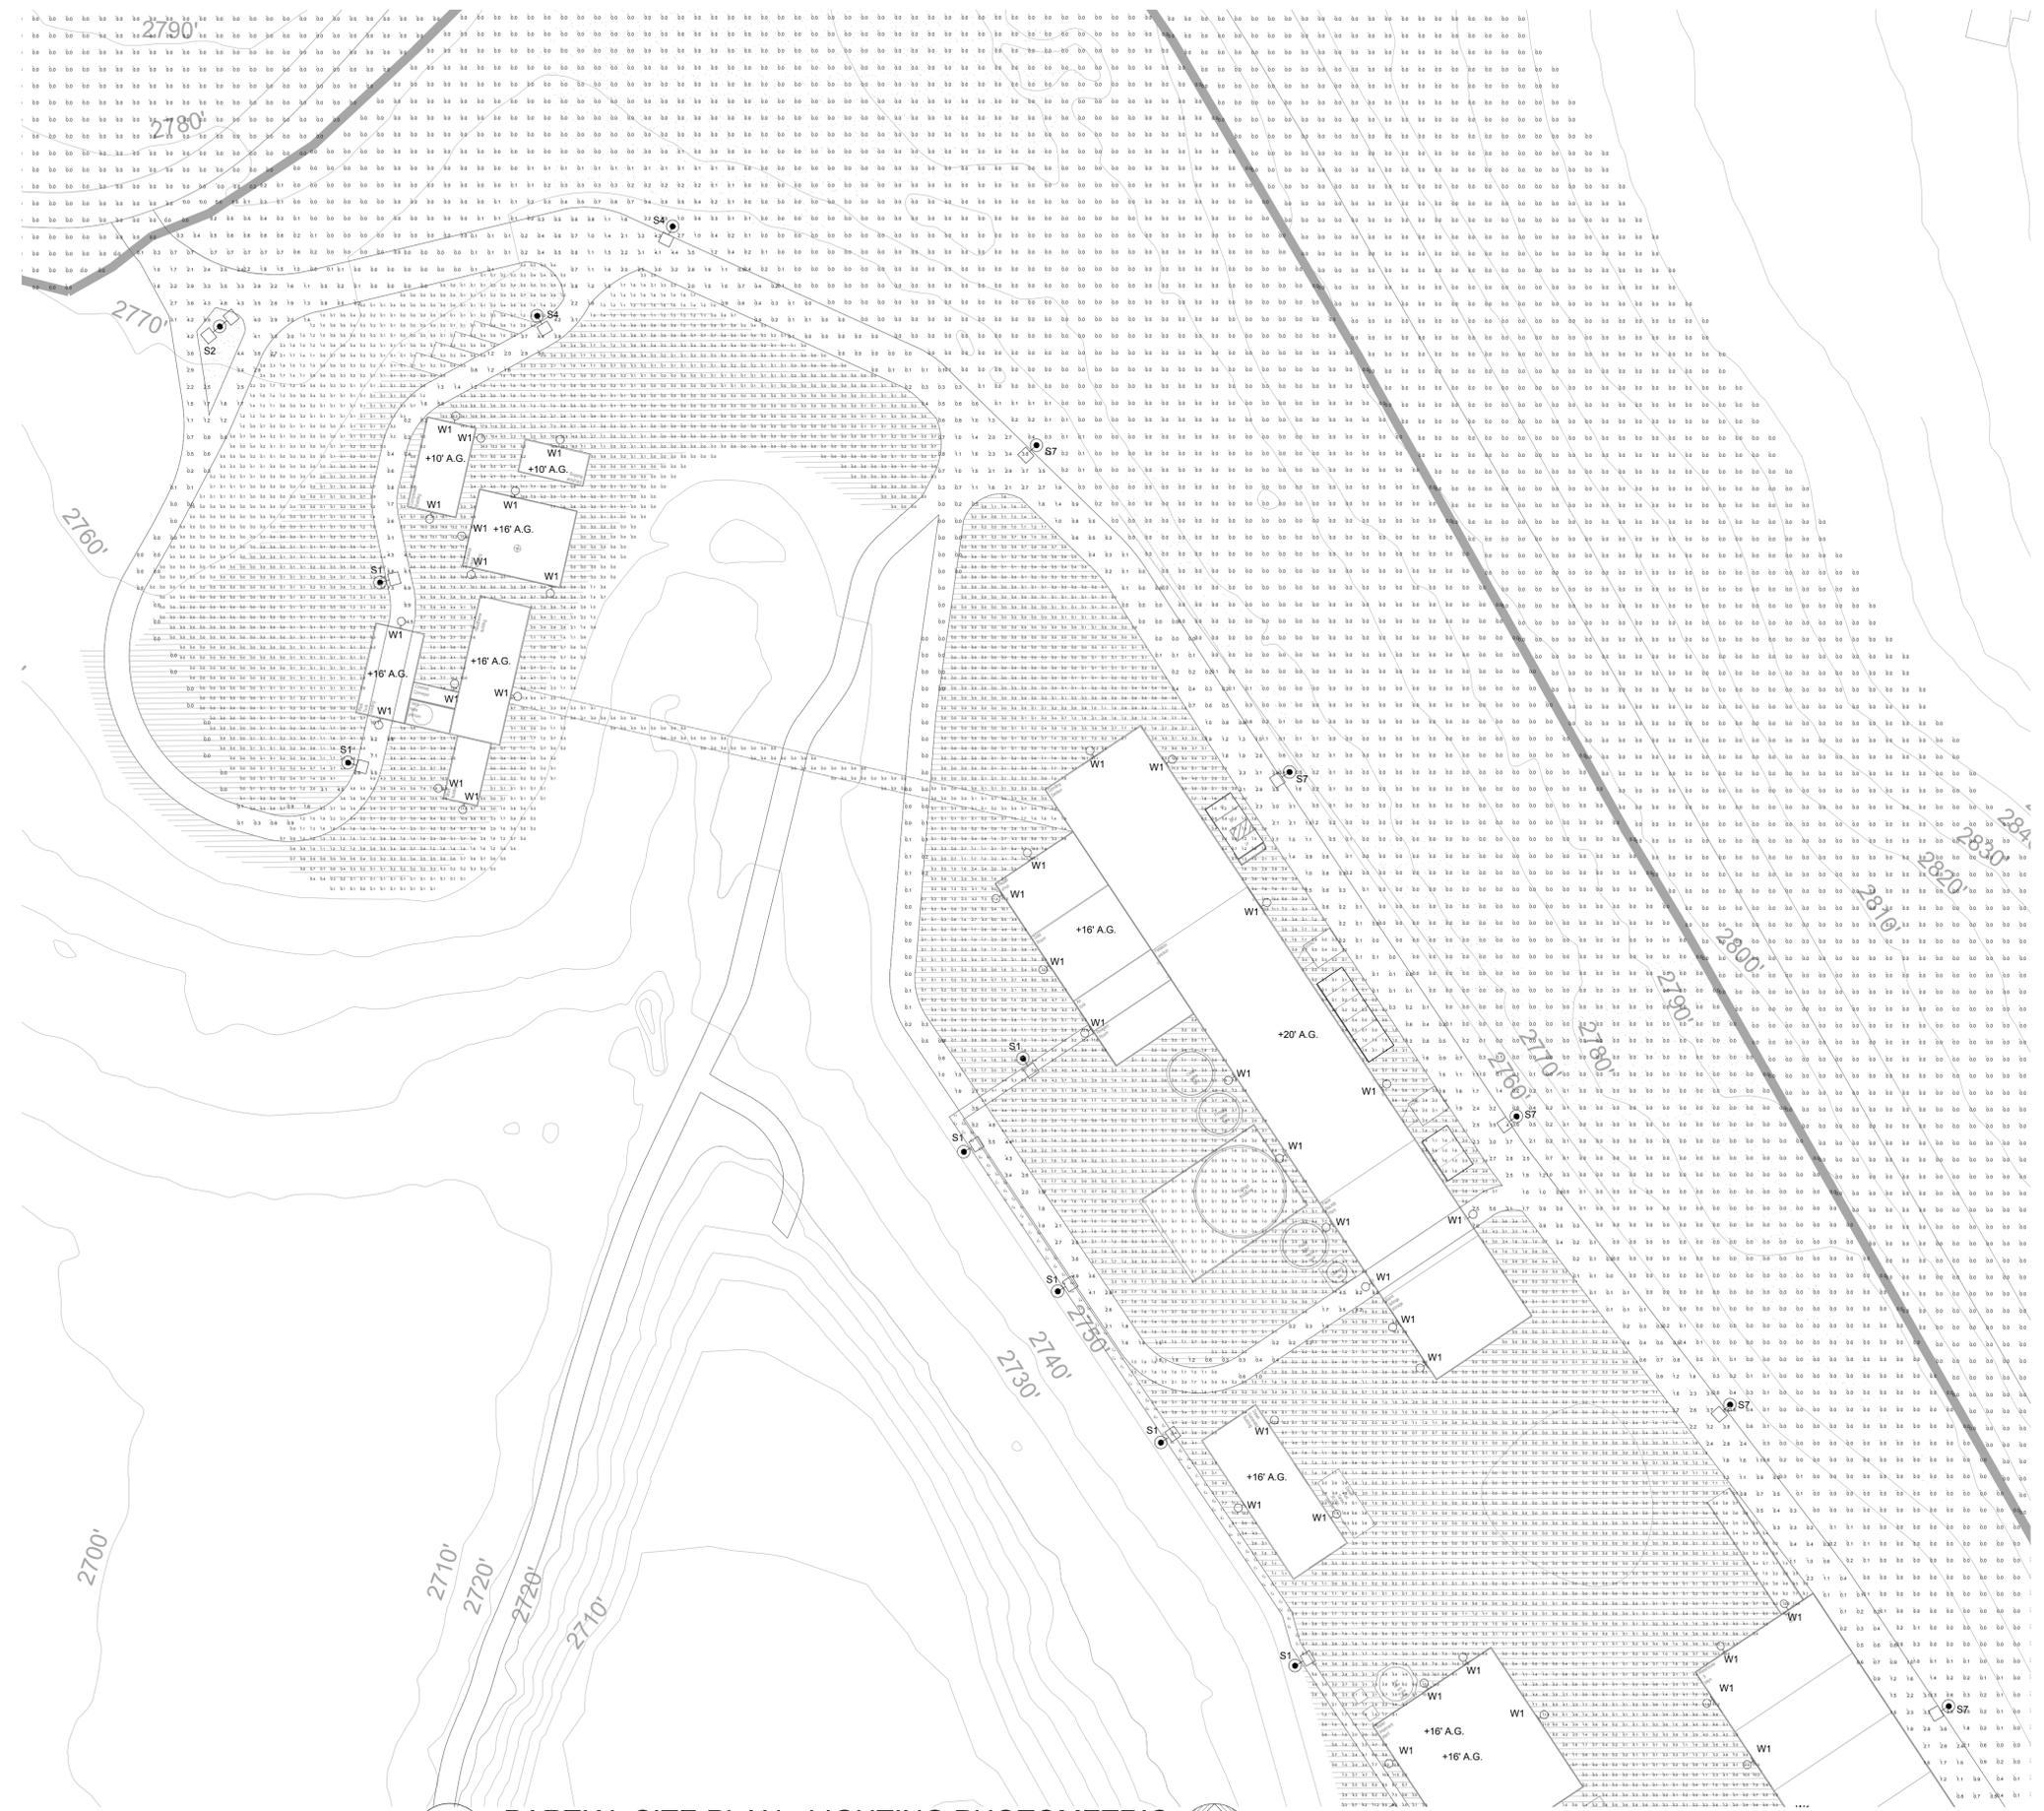

1
E110

PARTIAL SITE PLAN - LIGHTING PHOTOMETRIC

SCALE: 1" = 50'-0"



No.	REVISIONS	DATE	BY
1		X/XX/XX	

M. NEILS
ENGINEERING, INC.
Electrical Engineers | Lighting Designers
100 Howe Ave., Suite 235N
Sacramento, CA 95825-8217
www.mneilsengineering.com
Tel: (916) 923-4400 Fax: (916) 923-4410
PROJECT #: 19301.21

REGISTERED PROFESSIONAL ENGINEER
JESSE U. BASTIAN
No. E20229
Exp. 03-31-21
Jesse U. Bastian
ELECTRICAL
STATE OF CALIFORNIA
01-17-20

SHEET TITLE:
**PARTIAL SITE PLAN -
LIGHTING
PHOTOMETRIC**

PROJECT:
**Idaho-Maryland Gold Project
Rise Grass Valley Inc.
PO Box 271
Grass Valley, California, USA 95945**

Date:	11-11-19
Checked:	JUB
Drawn:	SG
Scale:	AS NOTED

Sheet
E110
Of Sheets